


ABBREVIATIONS									
&	And	E	East	K	Kip (1,000 lbs)	RESIL	Resilient		
L	Metal Angle	EA	Each	K-FT	Kip Feet	RET	Return		
@	At	EB	Electric Baseboard	KVA	Kilovolt Amps	REV	Revisions, Revised		
#	Pound or Number	EF	Exhaust Fan	KW	Kilowatts	RFG	Roofing		
		EJ	Expansion Joint			RH	Right Hand		
		EL	Elevation			RM	Room		
A, AMP	Ampere or Amperage	ELEC	Electrical	LAM	Laminated	RO	Rough Opening		
AB	Anchor Bolt	ELEV	Elevator	LAV	Lavatory	RPM	Revolutions Per Minute		
A/C	Air Conditioning	EMERG	Emergency	LB	Pound	RWL	Rain Water Leader		
ACOUS	Acoustical	ENCL	Enclosure	LCC	Lead Coated Copper	RV	Roof Vent		
ACT	Acoustical Ceiling Tile	ENGR	Engineer	LF	Linear Feet				
ACU	Air Conditioning Unit	EP	Electrical Panel	LH	Left Hand				
ADDN	Addition	EQ	Equal	LL	Live Load	S	South		
ADDNL	Additional	EWC	Electric Water	LP	Lighting Panel	S/A	Supply Air		
ADJ	Adjustable	EXH	Exhaust	LT(G)	Lighting	S&R	Supply & Return		
AFF	Above Finish Floor	EXIST	Existing	LVL	Laminated Veneer Lumber	S&B	Sound Attenuating Fiber Blanket		
AHU	Air Handling Unit	EXP	Expansion			SAN	Sanitary		
ALT	Alternate	EXT	Exterior			SCHED	Schedule		
ALUM	Aluminum			MAS	Masonry	SERV	Service		
ANCH	Anchor, Anchorage	FA	Fire Alarm	MAX	Maximum	SF	Square Feet		
ANOD	Anodized	FACP	Fire Alarm Control Panel	MCM	Metal Composite Material	SGFT	Structural Glazed Facing Tile		
ARCH	Architect, Architectural	FC(U)	Fan Coil Unit	MDP	Main Distribution Panel	SHT	Sheet		
		FD	Floor Drain	MECH	Mechanical	SIM	Similar		
		FDN	Foundation	MED	Medium	SP	Static Pressure		
BD	Board	FEC	Fire Extinguisher & Cabinet	MEMB	Membrane	SPEC	Specifications		
BIT	Bituminous	FEN	Fire Extinguisher	MET	Metal	SQ	Square		
BLDG	Building	FEC	Fire Extinguisher & Cabinet	MET	Metal	SS	Stainless Steel		
BLK(G)	Blocking	FF	Finished Floor	MFR	Manufacturer	ST	Storm		
BM	Beam	FLUOR	Fluorescent	MIN	Minimum	STD	Standard		
BM	Bench Mark	FOS	Fuel Oil Supply	MISC	Miscellaneous	STL	Steel		
BOT	Bottom	FOR	Fuel Oil Return	MO	Masonry Opening	STRUC	Structural		
BRG	Bearing	FPRF(G)	Fireproofing	MR	Moisture Resistant	SW, SW BD	Switch, Switch Board		
BRK	Brick	FR	Frame	MTD	Mounted	SWGR	Switchgear		
BSMT	Basement	FT	Foot, Feet			SYM	Symmetrical		
BUR	Built Up Roof	FTG	Footing						
		FURN	Furnish(ed)	N	North				
		FURR	Furring	NIC	Not In Contract				
C	Course			NOM	Nominal	T	Tread, Thermostat		
CAB	Cabinet			NTS	Not To Scale	TBH	Thousand BTU per Hour		
CD	Condensate Drain	GA	Gauge, Gage	O/A	Outdoor Air	T&B	Top & Bottom		
CEF	Ceiling Exhaust Fan	GALV	Galvanized	OC	On Center	T&G	Tongue & Groove		
CEM	Cement	GB	Gypsum Board	OD	Outside Diameter				
CFM	Cubic Feet Per Minute	GC	General Contractor	OPG	Opening	T/F	Top of Frame		
CG	Corner Guard	GFI	Ground Fault Interrupter	OPP	Opposite	T/M	Top of Masonry		
CHP	Cabinet Heat Pump	GL	Glass, Glazing	OZ	Ounce	T/S	Top of Steel		
CI	Cast Iron	GND	Ground	PA	Public Address	T/W	Top of Wall		
CJ	Control Joint	GR	Grade	PCF	Pounds Per Cubic Foot	TEL or TELE	Telephone		
CKT	Circuit	GYP	Gypsum	PERF	Perforated	TEMP	Temperature		
CLG	Ceiling			PG	Paint Grade	THK	Thick(ness)		
C	Center Line	HB	Hose Bibb	PL	Plate	THRES	Threshold		
CLR	Clear	HDWD	Hard Wood	PL	Plate	TR	Trash		
CMU	Concrete Masonry Unit	HDWE	Hardware	PLAM	Plastic Laminate	TRANS	Transformer		
CO	Clean Out	HGT	Height	PLAS	Plaster	TYP	Typical		
COL	Column	HID	High Intensity Discharge	PLBG	Plumbing				
CONC	Concrete	PLYWD	Plywood	POL	Panel	UG	Under Ground		
CONN	Connection	PNL	Panel	POL	Polished	UH	Unit Heater		
CONST	Construction	PP	POWER & EYE	PP	POWER & EYE	UON	Unless Otherwise Noted		
CONT	Continuous	HP	High Point, Horse POWER & EYE	WASH	Wash Panel				
CONTR	Contract(or)	WASH	Wash Panel	PR	Pair	UNO	Unless Noted Otherwise		
CP	Condensate Pump	HTG	Heating	PRTN	Partition				
CPT	Carpet	HTR	Heater	PSF	Pounds Per Square Foot	UV	Unit Ventilator		
CR	Ceiling Register	HVAC	Heat, Vent, & A/C			V	Vent, Volt		
CT	Ceramic Tile	HVU	Heating & Vent. Unit	PSI	Pounds Per Square Inch	AV	Variable Air Volume		
CTR	Center	HW	Hot Water	PT	Paint/ Painted	VCT	Vinyl Composition Tile		
CUH	Cabinet Unit Heater	HWV	Hot Water Heater	PV	Plumbing Vent	VERT	Vertical		
CW	Cold Water	HWH	Hot Water Heater	PVMT	Pavement	VENT	Ventilator		
		HZ	Hertz	QT	Quarry Tile	VHP	Vertical Heat Pump		
D	Diffuser	IN	Inch	QTY	Quantity	VIF	Verify in Field		
DBL	Double	INCAND	Incandescent	R	Riser, Register	VIN	Vinyl		
DET	Detail	INCL	Include(d), (ing)	R/A	Return Air	VWC	Vinyl Wallcovering		
DF	Drinking Fountain	INS	Insulate(d), (ing)	RAD	Radius	W	Watts, West		
DIA	Diameter	INT	Interior	RCP	Reinforced Concrete	WB	Wet Bulb		
DIM	Dimension	INV	Invert			W/	With		
DISP	Dispenser					WO	Without		
				RD	Roof Drain	WC	Water Closet		
DL	Dead Load	JB, JBOX	Junction Box	RECPT	Receptacle	WD	Wood		
DN	Down	JST	Joist	RE	Recycle	WP	Waterproof		
DO	Ditto	JT	Joint	REF	Reference	WR	Water Resistant		
DP	Distribution Point			REFIN	Refinish	W	Wains		
DR	Door			REINF	Reinforce(d), (ing)	WT	Weight		
DWG	Drawing			REQ	Required	WWF	Welded Wire Fabric		
				RL	Roof Leader	YD	Yard		


GRAPHIC LEGEND

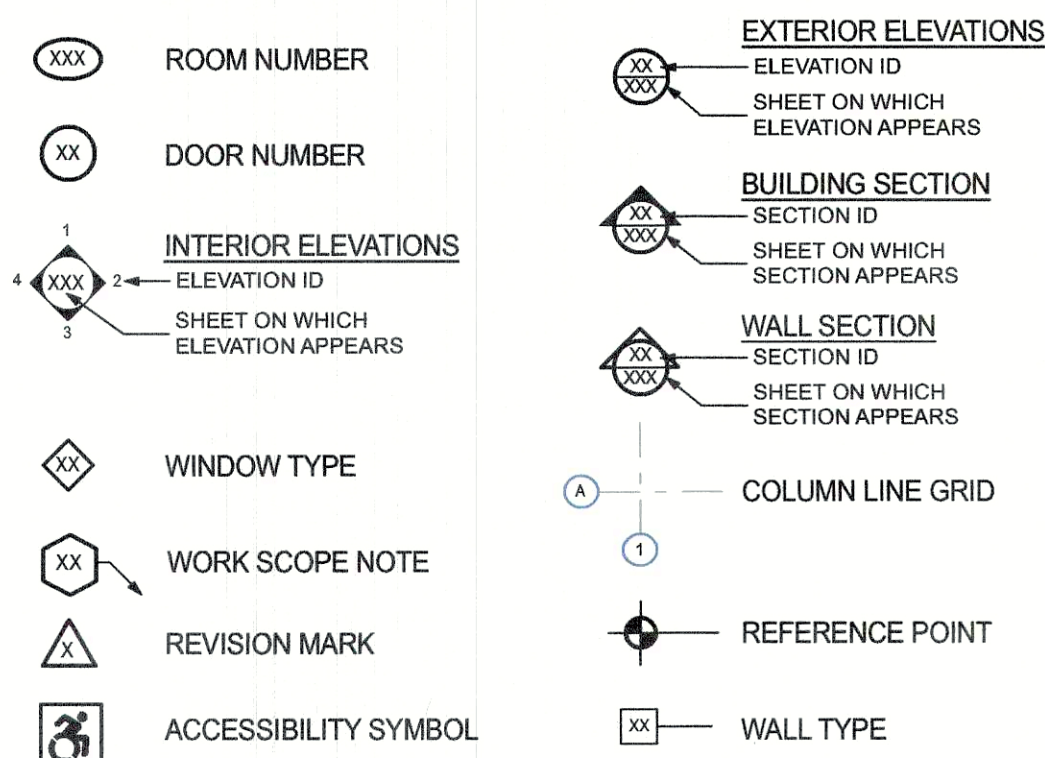


DRAWING LIST

ID	NAME
A-001	COVER SHEET
A-002	INFO SHEET
A-003	CODE SHEET
AD-101	EXISTING CONDITION AND DEMO PLANS
A-111	1st FLOOR CONSTRUCTION PLAN
A-112	1st FLOOR REFLECTED CEILING PLAN
A-113	ENLARGED PLANS AND TYP WALL TPYES


MATERIALS LEGEND

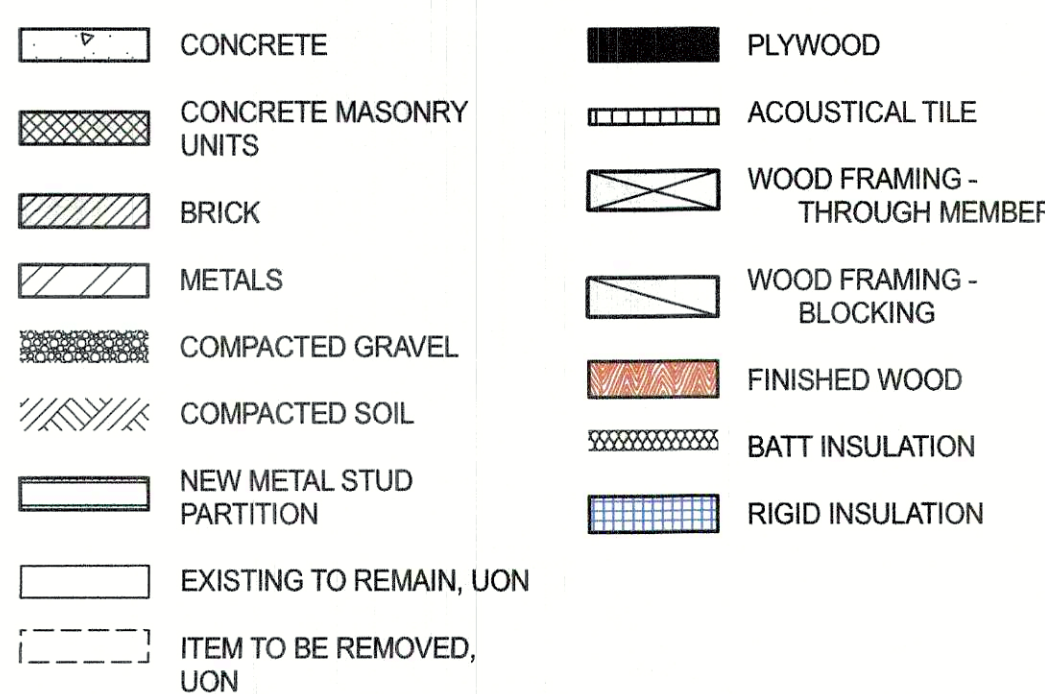

FIXTURE AND ACCESSORY MOUNTING HEIGHTS

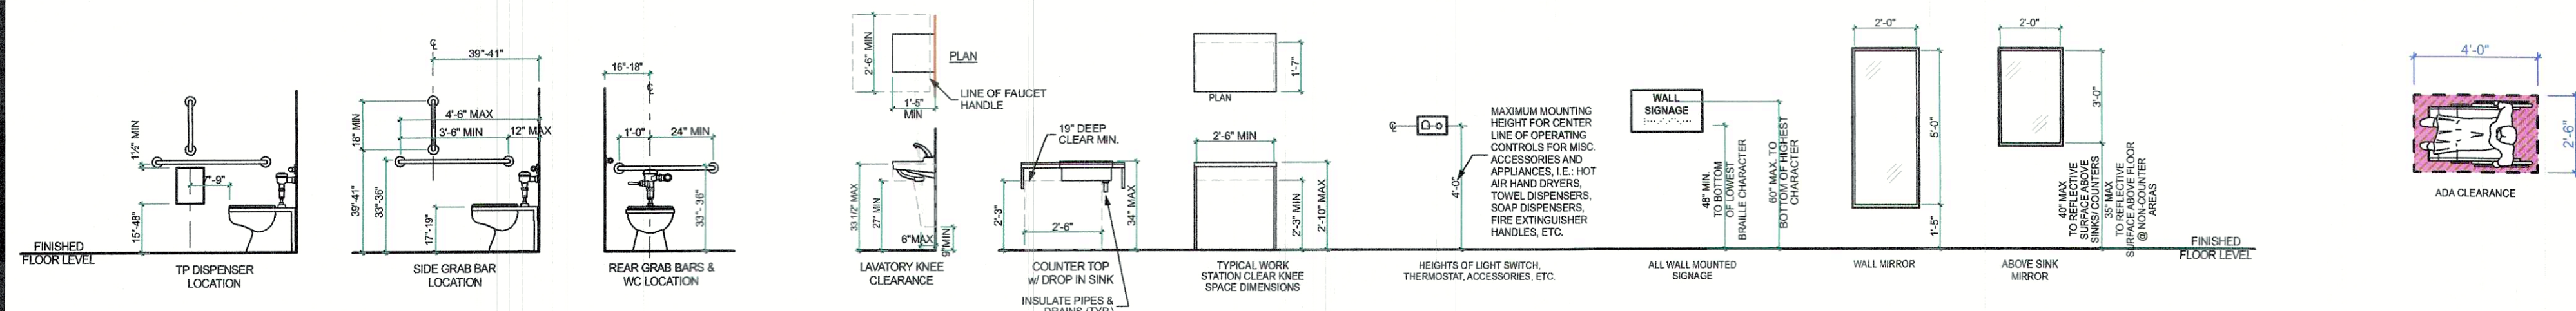


REGION MAP (NTS)

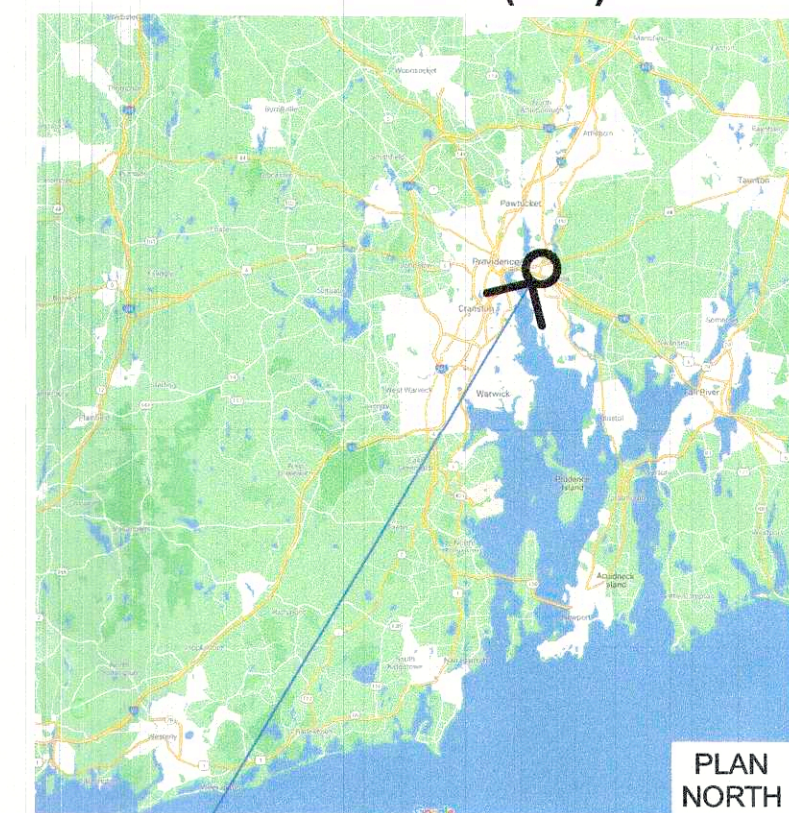


PROJECT LOCATION

LOCATION MAP (NTS)

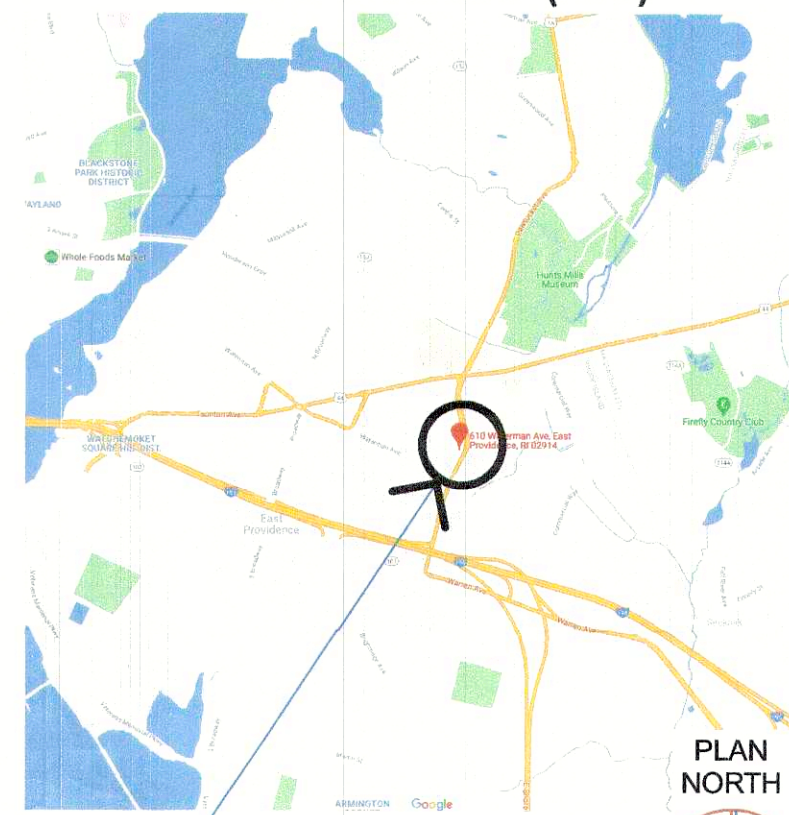


PROJECT LOCATION

LOCATION MAP (NTS)

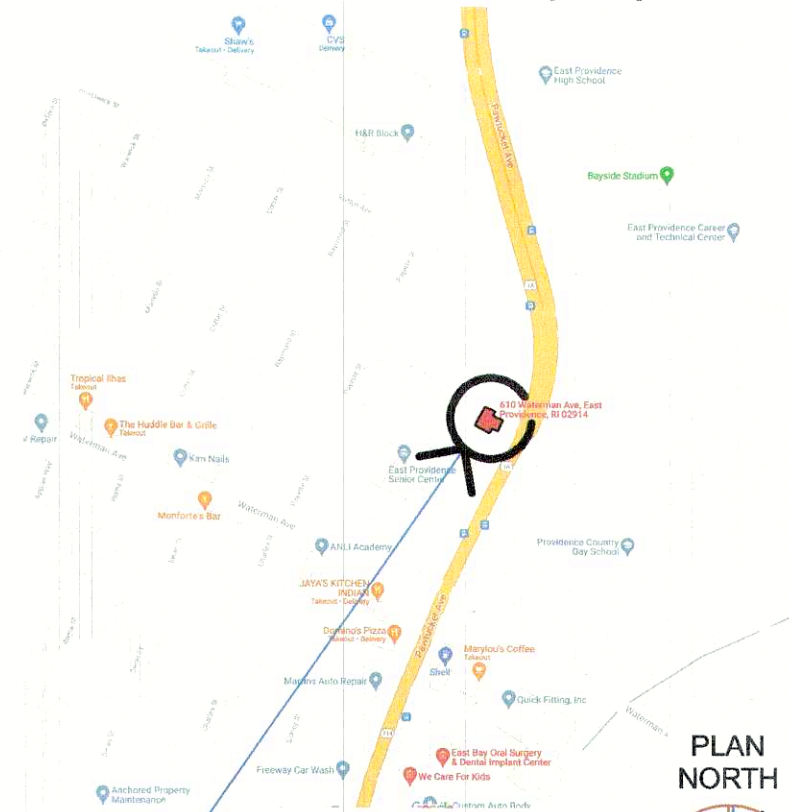

PROJECT LOCATION

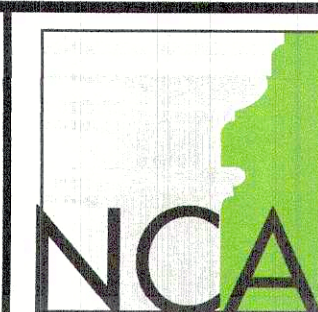


NORTHEAST
COLLABORATIVE
ARCHITECTS
650 Ten Rod Road, Unit 4
North Kingstown, RI 02852
v: 401.846.9583 x 3005



EBCAP - SWEETLAND HOUSE

610 Waterman Street
East Providence, RI 02914

REVISIONS:

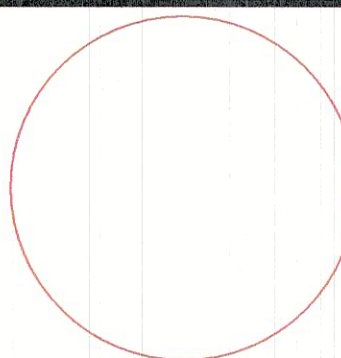

INFO SHEET

DATE: 10.06.2021

NCA JOB NO.: 21110

DRAWING NO.:

A-002

PRINTED: Wednesday, October 6, 2021, 6:32 PM

**RHODE ISLAND STATE
BUILDING CODE INFORMATION:**
RISRC-1 State Rehabilitation Building and Fire Code for Existing Structures

RHODE ISLAND STATE FIRE SAFETY CODE (RISFSC)
2015 International Fire Code
2015 NFPA 1, Fire Code
2015 NFPA 101, Life Safety Code

RHODE ISLAND FIRE PREVENTION CODE (RIFPC)
2012 NFPA 1, Uniform Fire Code w/ 2015 RISFSC regulations


RI Department of Health REQUIREMENTS:
The project shall also meet the FGI Guidelines for Design and Construction of Outpatient Facilities (2014).




NORTHEAST
COLLABORATIVE
ARCHITECTS
650 Ten Rod Road, Unit 4
North Kingstown, RI 02852
v: 401.846.9583 x.3005



EBCAP - SWEETLAND HOUSE
610 Waterman Street
East Providence, RI. 02914

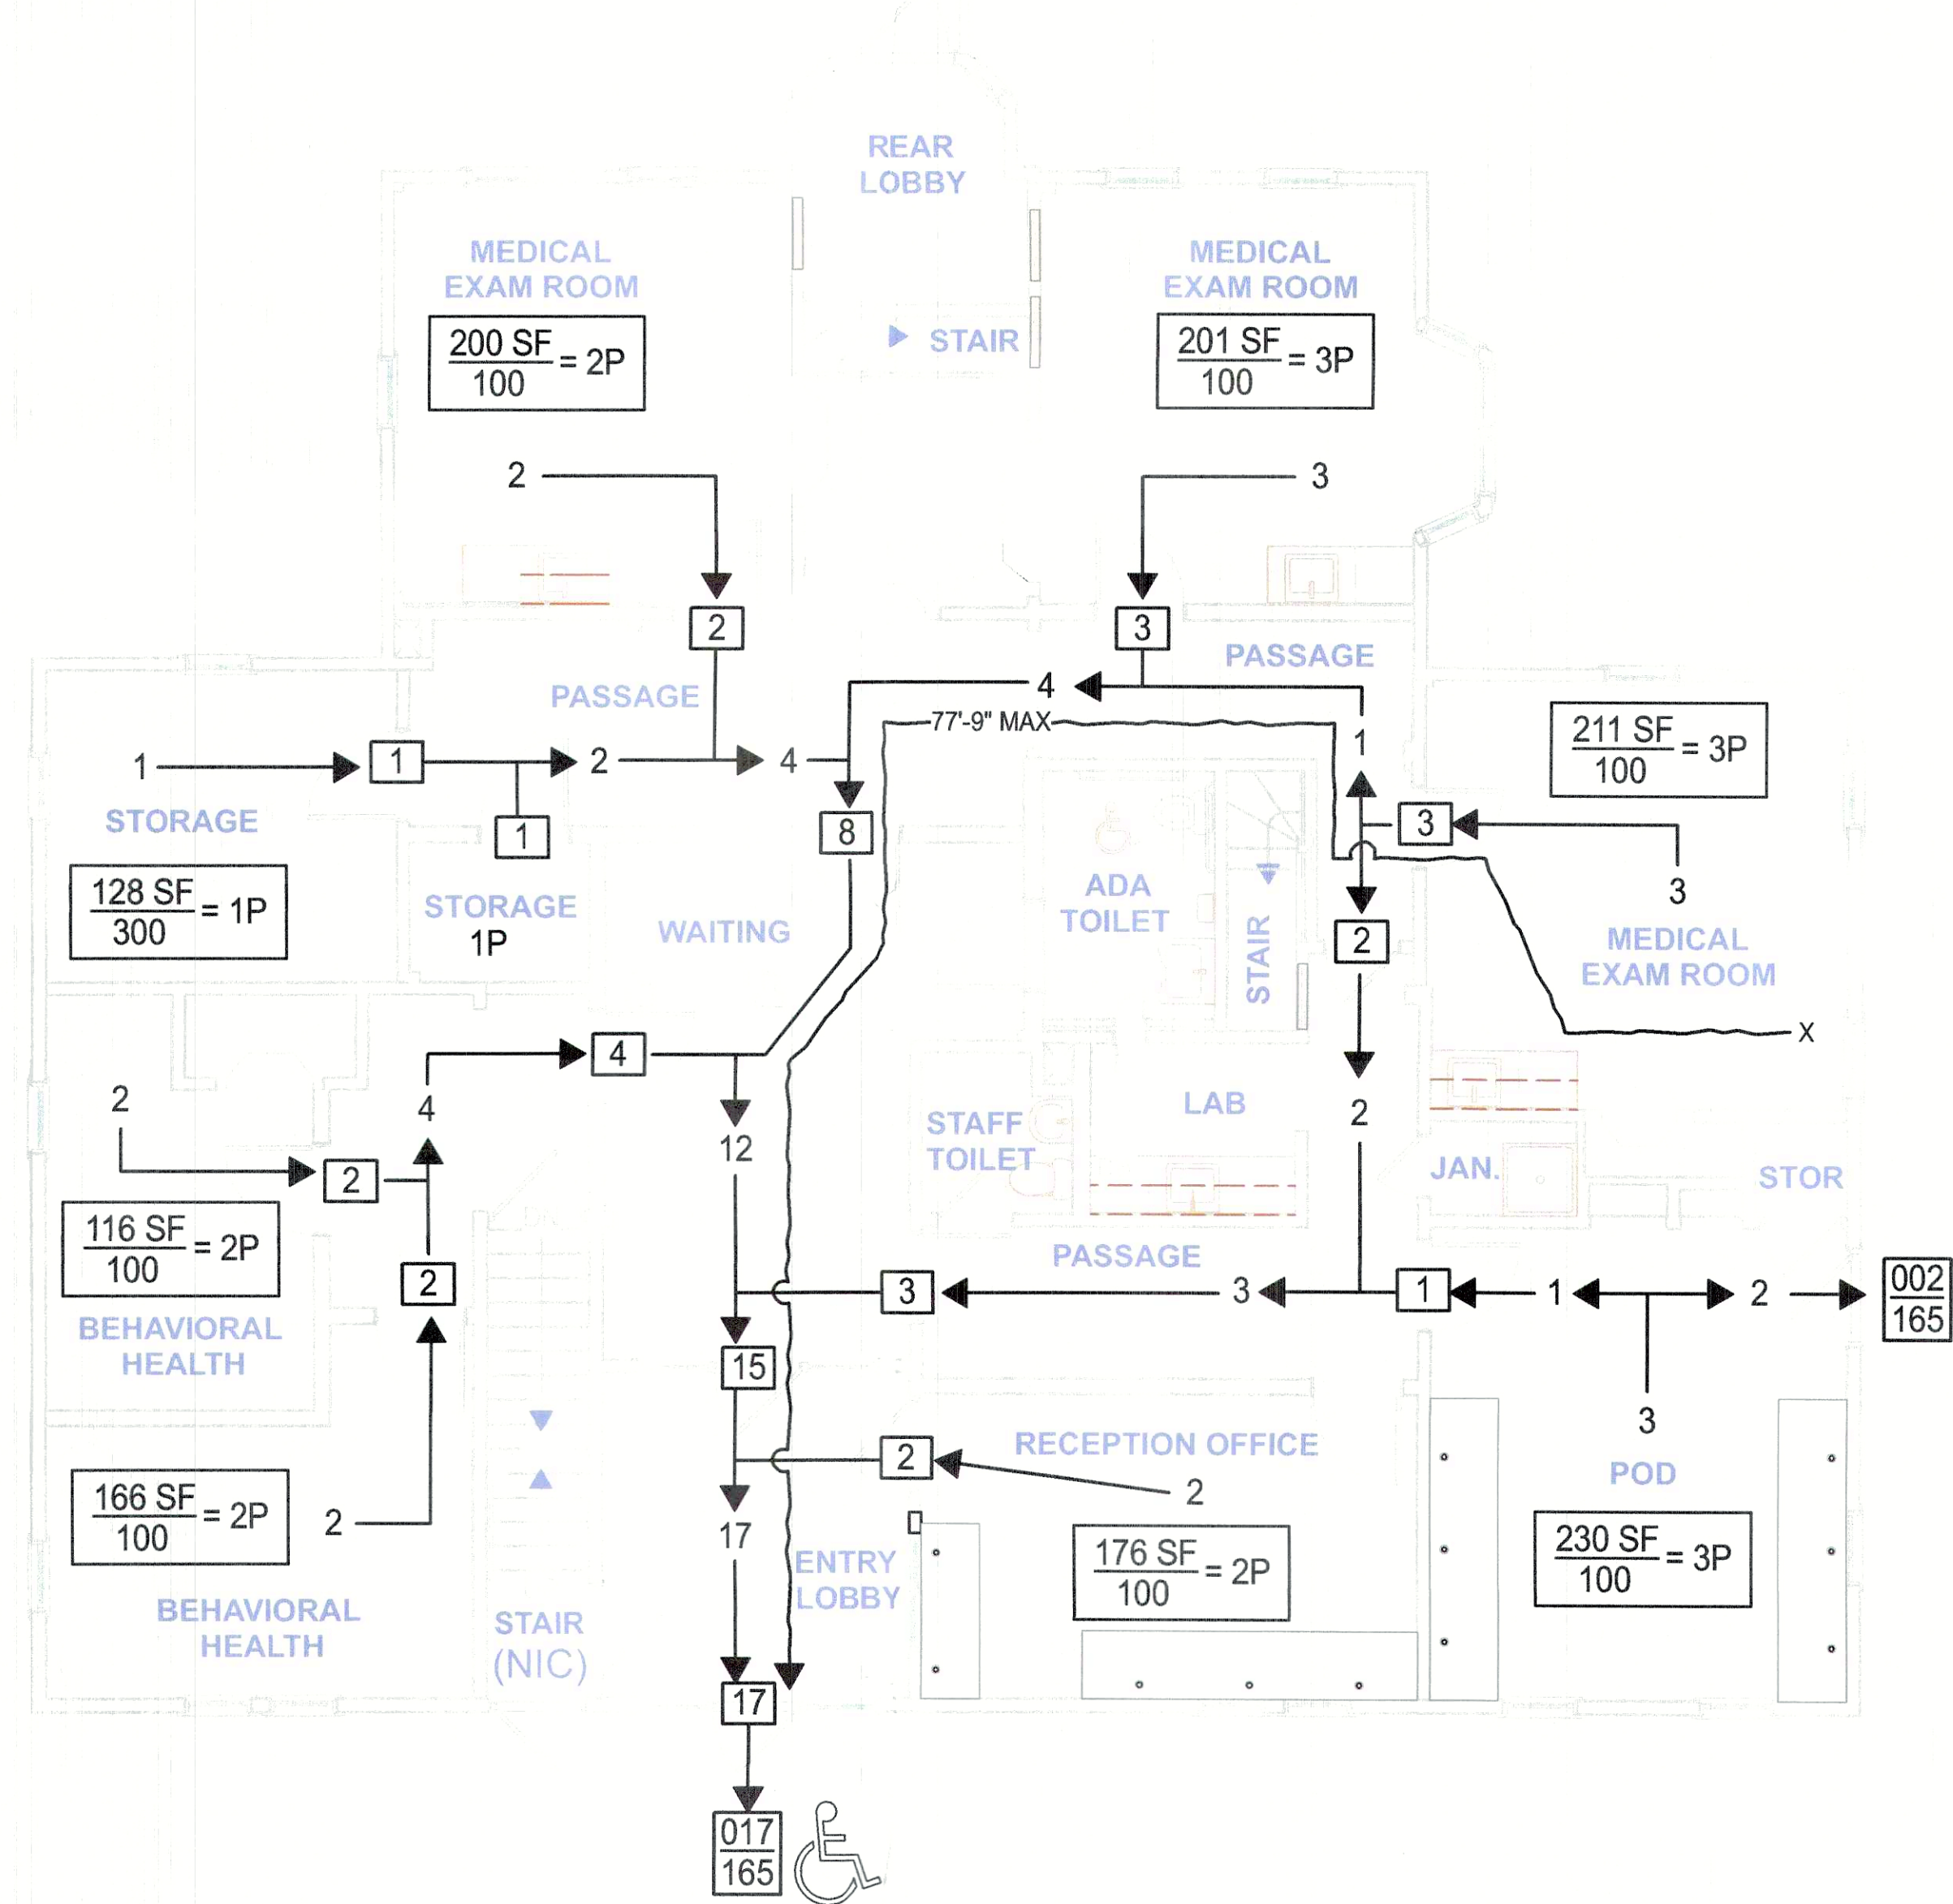


**A2
A-003** 1st FLOOR EGREE PLAN
SCALE: 3/16" = 1'-0"

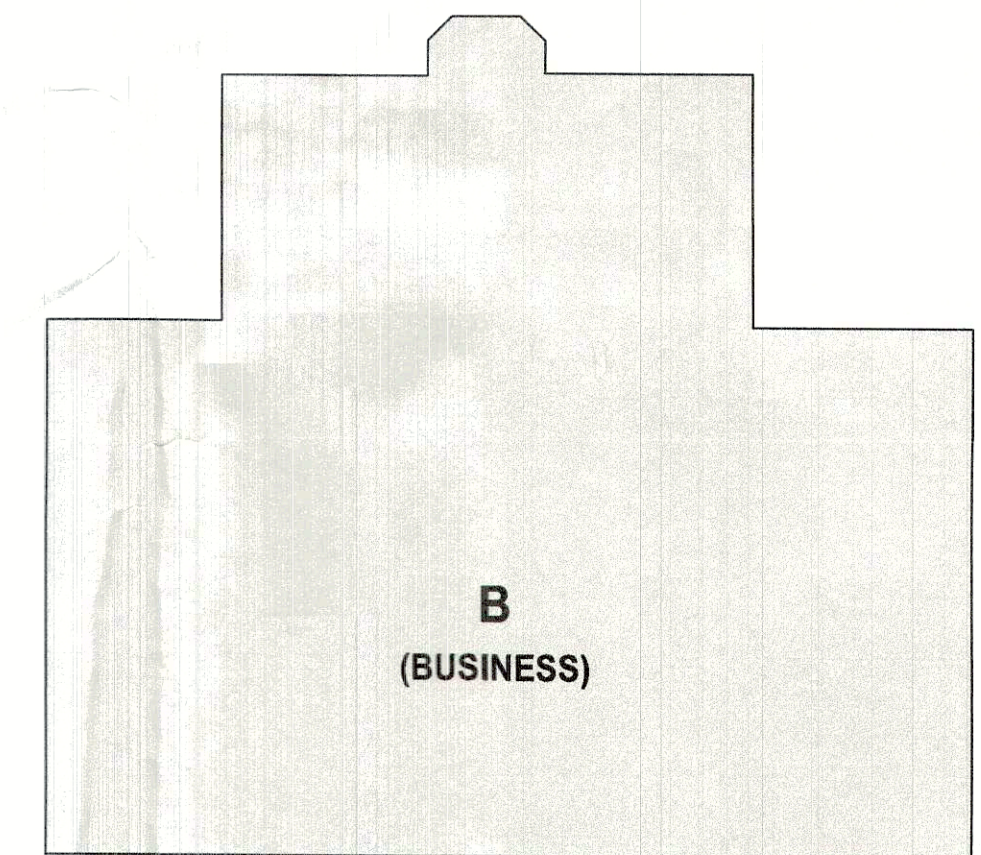

FIRST FLOOR:
CLASSIFICATION OF OCCUPANCY - NO CHANGE
CONSTRUCTION TYPE:
EXISTING
Minimum Type of Construction Required: IIB
Actual Type of Construction Provided: IIB

SYMBOLS LEGEND	
XX XX	ROOM OCCUPANCY LOAD
	AREA IN SQUARE FEET OCCUPANCY LOAD FACTOR
X XXX	EXIT CAPACITY
	ACTUAL EGRESS OCCUPANCY OF DOOR OR STAIR MAXIMUM ALLOWABLE EGRESS OCCUPANCY OF DOOR OR STAIR
XX	DIRECTION OF TRAVEL ACTUAL EGRESS OCCUPANCY OF PASSAGE OR STAIR
XXX'	MAXIMUM TRAVEL DISTANCE FROM FURTHEST POINT
	ACCESSIBLE AREA OR EXIT
---	1 HOUR FIRE RATING
----	2 HOUR FIRE RATING

REVISIONS:

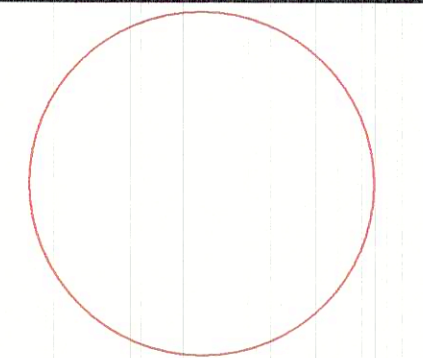

CODE SHEET

DATE: 10.06.2021

NCA JOB NO.: 21110

DRAWING NO.:

A-003